



SOUTH ELEVATION

1

KEY NOTES

- 1 STUCCO OVER 2X STUD CONSTRUCTION
- 2 PREFAB FOAM CORNICE W/SMOOTH STUCCO FINISH
REFER TO PRIMARY AND SECONDARY CORNICE DETAILS 8, 11 & 12/AD-3.
- 3 STUCCO EXPANSION JOINT, SEE DETAIL 3/AD-4.
- 4 STOREFRONT GLAZING SYSTEM, STOREFRONT WINDOW DETAILS, SHEET 3/A2
- 5 DESIGNATED SIGNAGE PER TENANT, UNDER SEPERATE PERMIT
- 6 METAL AWNING OVER WOOD FRAMING,
SEE DETAILS 21, 22 & 23/AD-9
- 7 WALL MOUNT LIGHTING, REFER TO ELECTRICAL PLANS FOR FIXTURE TYPE.
- 8 STONE VENEER BY: ELDORADO
STACKED STONE, "SANTIA TE"
- 9 KNOX BOX @ 66" A.F.F.
- 10 ROOF LINE
- 11 DRIVE THRU WINDOW, REFER TO DETAIL 13 & 15/AD-10.
- 12 OMITTED (EXTERIOR ROOF LADDER)
- 13 BUILDING ADDRESS, SHALL BE 8" TALL AND VISIBLE FROM STREET
COLOR AND NUMERALS SHALL CONTRAST WITH THE BACKGROUND.
- 14 ROOF MOUNTED MECH. UNIT, SEE MECHANICAL PLANS.
- 15 OMITTED
- 16 "SOLDIER" COURSE BRICK UNDER WINDOW SILL, SEE DETAIL 9/AD-10
- 17 OMITTED
- 18 GALVANIZED METAL AWNING OVER WOOD FRAMING, DRIVE-THRU
SEE DETAIL 21 & 22/AD-9
- 19 EXTERIOR METAL DOORS, REFER TO DOOR SCHEDULE FOR DETAILS.

COLOR SCHEDULE


- A MAIN BUILDING COLOR: SHERWIN WILLIAMS "ACCESSIBLE BEIGE", #SW7036
- B ACCENT COLOR: SHERWIN WILLIAMS "ARUGULA", #SW6446
- C SECONDARY BUILDING COLOR: SHERWIN WILLIAMS "CAVERN CLAY", #SW7701
- D DARK ANODIZED STORE FRONT FRAME & GLAZING PER T-24 TINTING



EAST ELEVATION

2

ZENDA JAS
2140 SO. RIVERSIDE AVENUE
RIALTO, CA

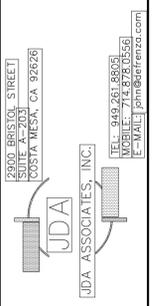


PER: 1997, 2007, 2012
APR: 0258-04-14-26&25
RIALTO PDRC LP
425 S. SAN GABRIEL BLVD #700
SAN GABRIEL, CA 91776
PH: (951)640-3708
AL STEWARD SR

ELEVATIONS
PROJECT ADDRESS
2140 SO. RIVERSIDE AVE.
RIALTO, CA 92376

NO.	DATE	DESCRIPTION



DATE
SHEET NUMBER
A5-1

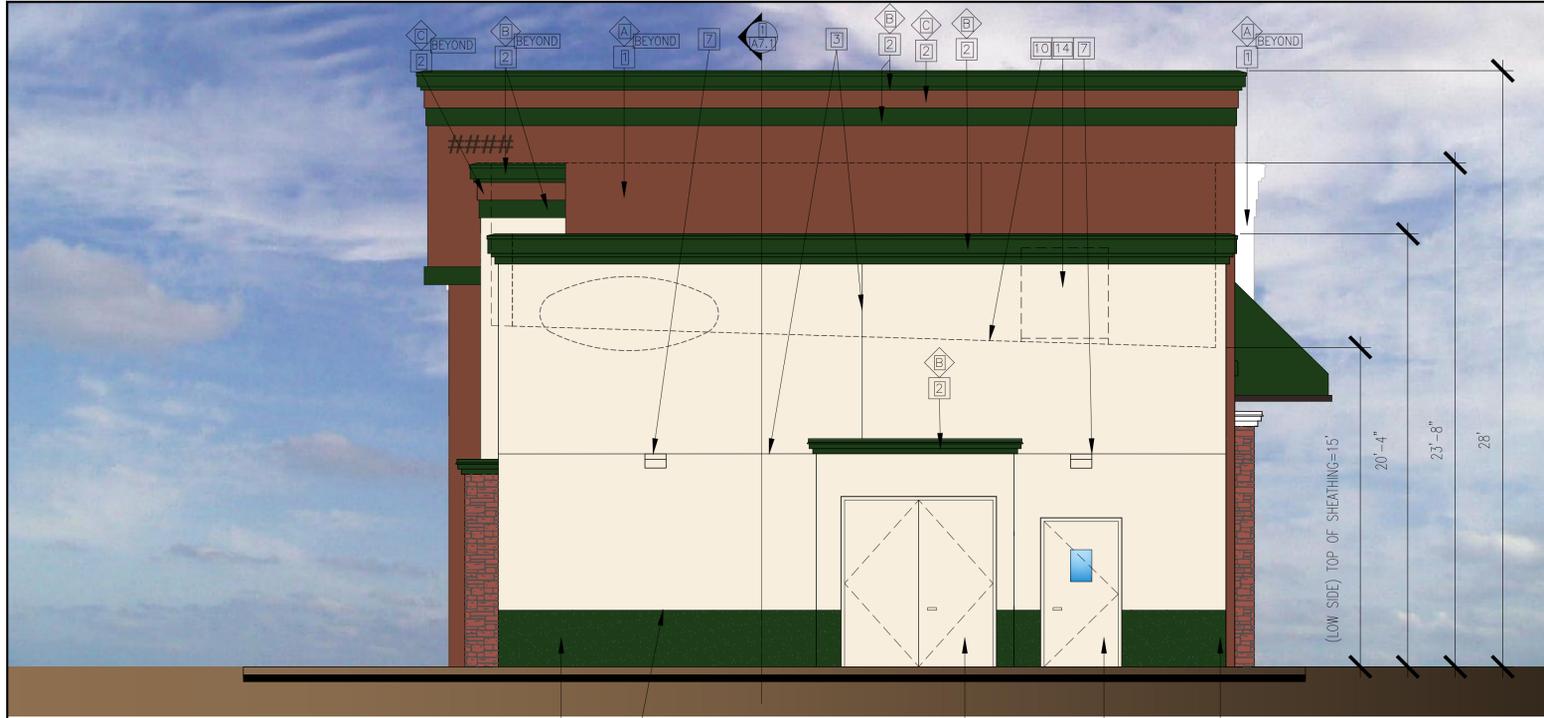

NORTH ELEVATION

3

COLOR SCHEDULE

- [A] MAIN BUILDING COLOR: SHERWIN WILLIAMS "ACCESSIBLE BEIGE", #SW7036
- [B] ACCENT COLOR: SHERWIN WILLIAMS "ARUGULA", #SW6446
- [C] SECONDARY BUILDING COLOR: SHERWIN WILLIAMS "CAVERN CLAY", #SW7701
- [D] DARK ANODIZED STORE FRONT FRAME & GLAZING PER T-24 TINTING

KEY NOTES


- [1] STUCCO OVER 2X STUD CONSTRUCTION
- [2] PREFAB FOAM FILLED ALUMINUM CORNICE W/GALVANIZED FINISH REFER TO PRIMARY AND SECONDARY CORNICE DETAILS 8, 11 & 12/AD-3.
- [3] STUCCO EXPANSION JOINT, SEE DETAIL 3/AD-4.
- [4] STOREFRONT GLAZING SYSTEM, STOREFRONT WINDOW DETAILS, SHEET 3/A2
- [5] DESIGNATED SIGNAGE PER TENANT, UNDER SEPERATE PERMIT
- [6] METAL AWNING OVER WOOD FRAMING, SEE DETAILS 21, 22 & 23/AD-9
- [7] WALL MOUNT LIGHTING, REFER TO ELECTRICAL PLANS FOR FIXTURE TYPE.
- [8] STONE VENEER BY: ELDORADO STACKED STONE, "SANTA FE"
- [9] KNOX BOX @ 66" A.F.F.
- [10] ROOF LINE
- [11] DRIVE THRU WINDOW, REFER TO DETAIL 13 & 15/AD-10.
- [12] EXTERIOR ROOF LADDER, REFER TO DETAIL X/XXX
- [13] BUILDING ADDRESS, SHALL BE 8" TALL AND VISIBLE FROM STREET COLOR AND NUMERALS SHALL CONTRAST WITH THE BACKGROUND.
- [14] ROOF MOUNTED MECH. UNIT, SEE MECHANICAL PLANS.
- [15] OMITTED
- [16] "SOLDIER" COURSE BRICK UNDER WINDOW SILL, SEE DETAIL 9/AD-10
- [17] OMITTED
- [18] GALVANIZED METAL AWNING OVER WOOD FRAMING, DRIVE-THRU SEE DETAIL 21 & 22/AD-9
- [19] EXTERIOR METAL DOORS, REFER TO DOOR SCHEDULE FOR DETAILS.



WEST ELEVATION

4

ZENDAJAS
2140 SO. RIVERSIDE AVENUE
RIALTO, CA

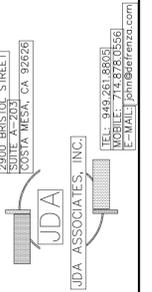

PER: 1997, B, 1997, B, 1997, B
APR: 0258-04-14-2662
RIALTO, PDRC, LP
425 S. SAN GABRIEL BLVD #700
SAN GABRIEL, CA 91776
PH: (951)640-3708
AL STEWARD SR

ELEVATIONS
PROJECT ADDRESS
2140 SO. RIVERSIDE AVE.
RIALTO, CA 92376

NO.	DATE	DESCRIPTION



DATE
SHEET NUMBER
A5-2